



FRONT ELEVATION

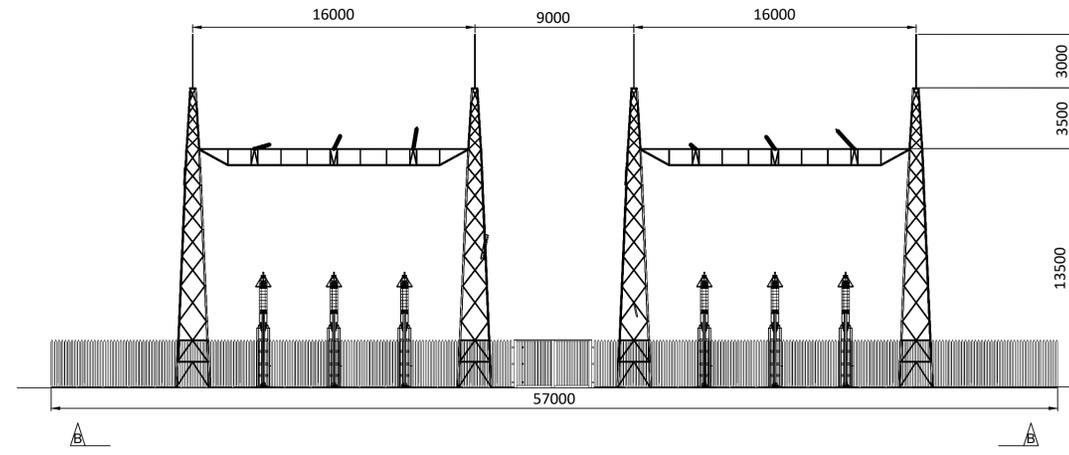


SCALE 1:200

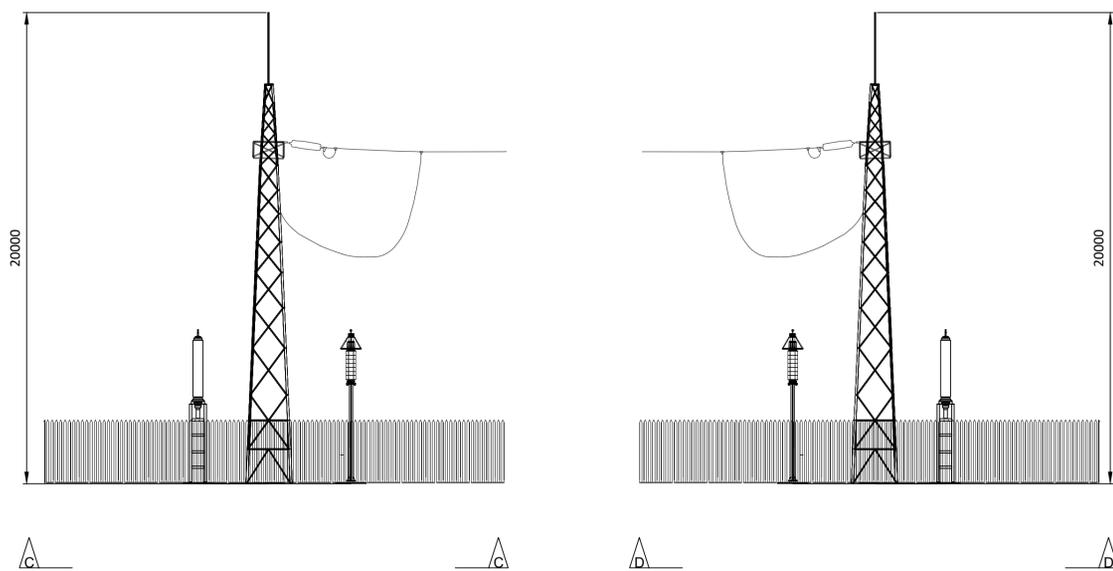

SIDE ELEVATION

SCALE 1:150

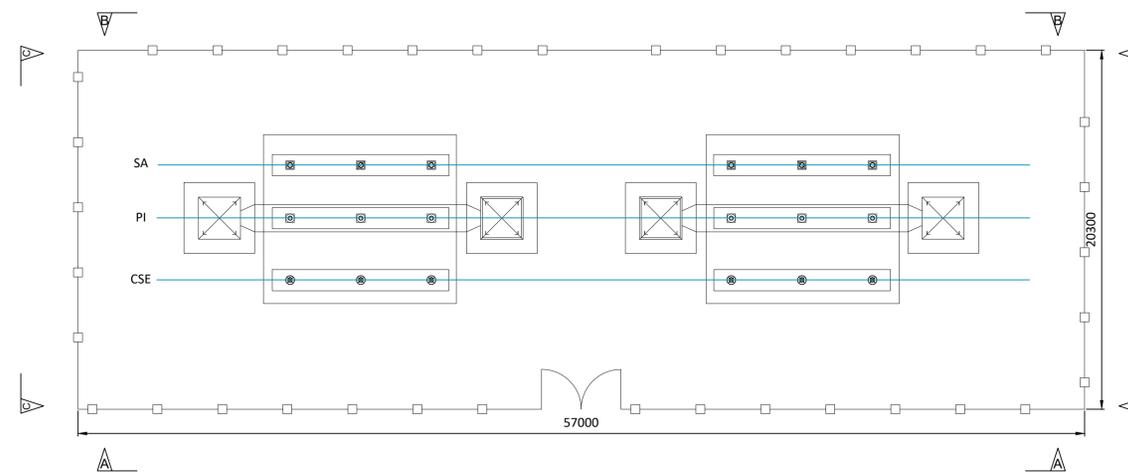

PLAN VIEW

SCALE 1:200

Notes:

- MEASUREMENTS SHOWN ARE IN MM, UNLESS INDICATED OTHERWISE
- DRAWING FOR PLANNING PURPOSES ONLY
- WHERE DRAWINGS ARE NOT SCALED, FIGURED DIMENSIONS ARE TO BE USED ONLY
- ABBREVIATIONS OF EQUIPMENT:

CSE	CABLE SEALING END
PI	POST INSULATOR
SA	SURGE ARRESTOR
- REFER TO DRAWING BNM-DPS-E-1002 FOR DETAILS OF 220 KV STRAIN TOWER

**	**	**
**	**	**
**	**	**
**	**	**
00	ISSUED FOR PLANNING	20/11/23
Rev.	DESCRIPTION	DATE

Bord na Móna

Main St, Newbridge, Co. Kildare
 Phone 045 439000
 www.bnm.ie
 Email: info@bnm.ie

© Copyright Bord na Móna Powergen Limited
 "Copyright and ownership of this drawing is vested in Bord na Móna Powergen Limited, whose prior written consent is required for its use, reproduction or for publication to any third party. All rights reserved by the law of copyright and by international copyright conventions are reserved to Bord na Móna Powergen Limited and may be protected by court proceedings for damages and/or injunctions and costs."

Project **DERRYGREENAGH POWER**

Client **BORD NA MÓNA POWERGEN LIMITED**

Drawing Title **220 KV LINE CABLE INTERFACE COMPOUND**

Date	Scale (A1)	Drawn by	Checked by	Approved by
20/11/23	AS SHOWN	JMcD	PC	JMcD

Status	FOR APPROVAL	<input type="checkbox"/>	Dwg. No.
PLANNING	FOR CONSTRUCTION	<input checked="" type="checkbox"/>	BNM-DPS-E-1005
TENDER	AS BUILT	<input type="checkbox"/>	