




Key Plan
1 : 6000

- NOTES:
- Building colours will range within a muted mid-dark grey and green spectrum. Refer to EIAI Vol. II, Appendix 10A for detail
 - Final detail of building finishes to be agreed with planning authority in advance of development commencing

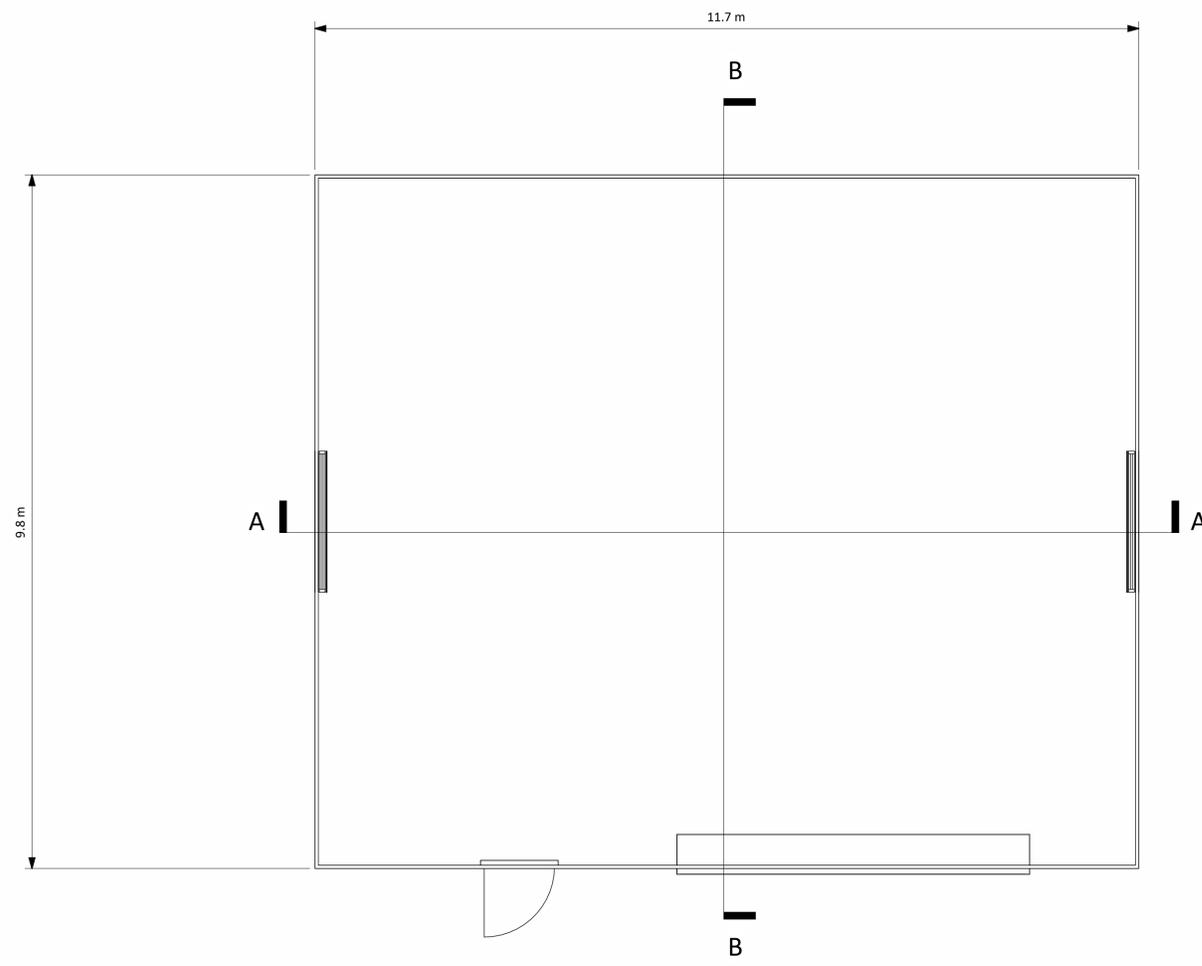

1 Lube Oil Store Floor Plan 85.250m AOD
1 : 50

R1.0	FOR PLANNING	DTW	AO1	BAB	26.01.24
REV.	DETAILS OF REVISION	DRAWN	CHKD	APR	DATE

FICHTNER
CONSULTING ENGINEERS LIMITED
7 Sir John Rogerson's Quay, Block C,
Grand Canal Docklands,
Dublin 2, D02 VK60
Tel: +353 (1) 506 0632
Website: www.fichtner.ie

CLIENT: **Bord na Móna Powergen Limited**

SITE:

PROJECT: **Derrygreenagh Power**

TITLE: **LUBE OIL STORE PLAN**

DRAWING STATUS: For Planning	
DRAWN BY: DTW	DATE: 26.01.24
CHECKED BY: AO1	DATE: 26.01.24
APPROVED BY: BAB	DATE: 26.01.24

FILENAME: OFFICE OF ISSUE: DUBLIN

SHEET SIZE: A1 SCALE: 1:50

DRAWING No.: **S7060-8050-0020** Sheet 1 of 1 REVISION: **R1.0**

