




1 Fire Water Pumphouse North Elevation
1 : 50

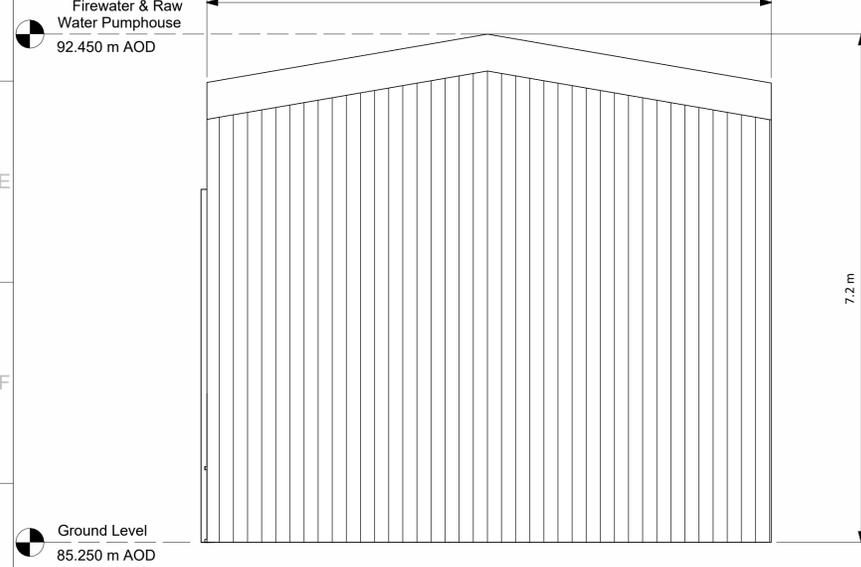


3 Fire Water Pumphouse South Elevation
1 : 50

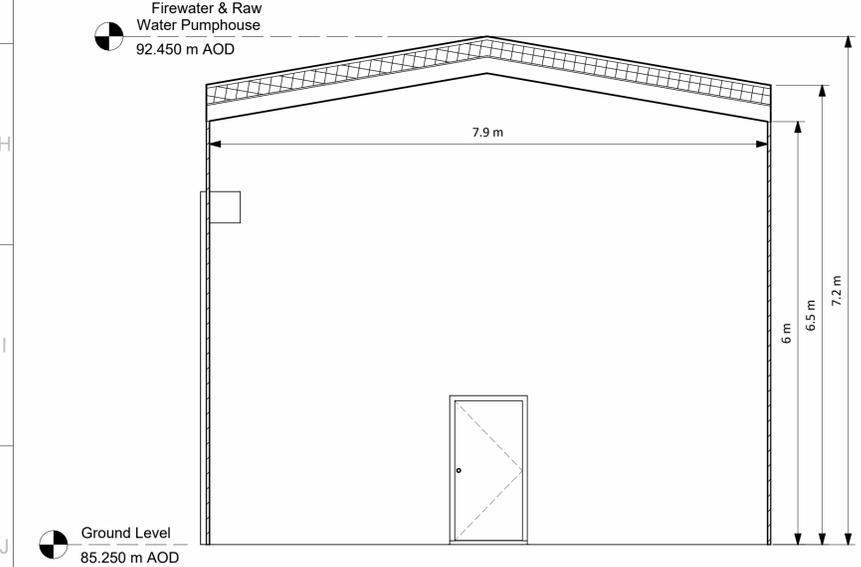

5 Firewater Pumphouse Section A-A
1 : 50

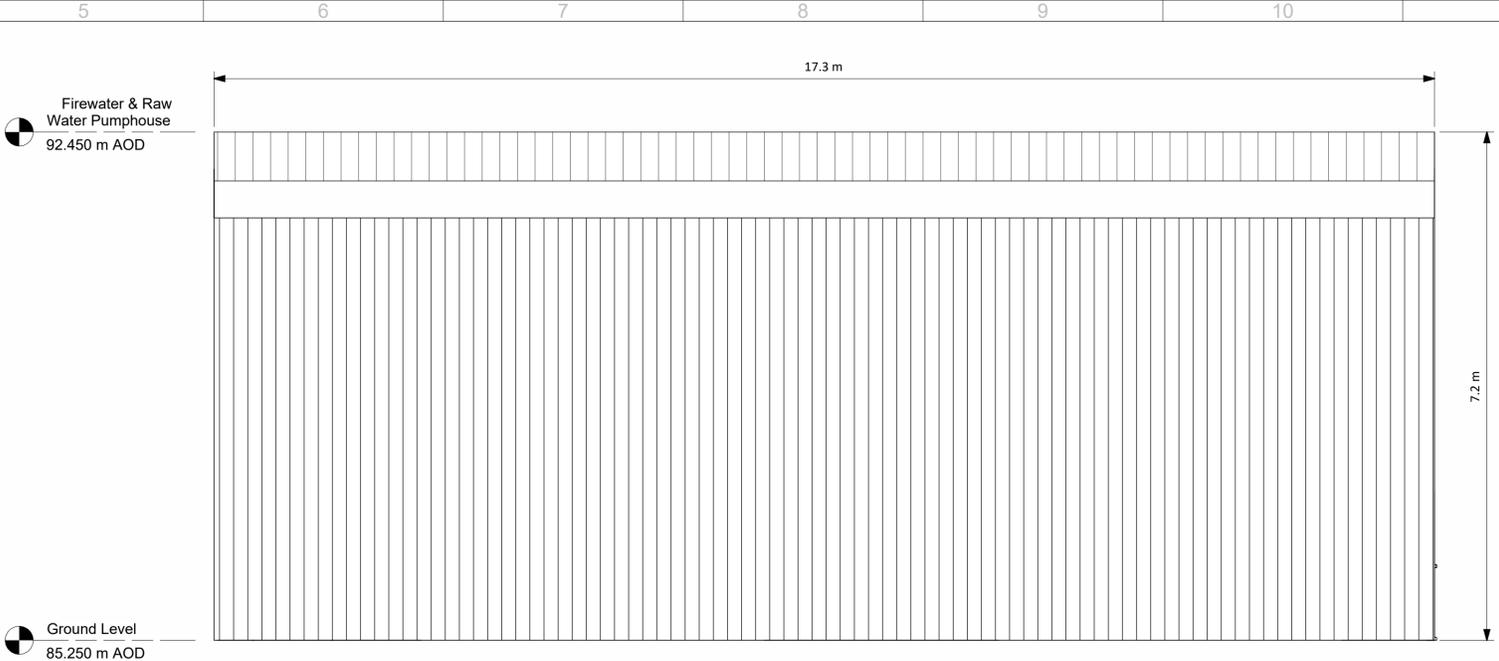


2 Fire Water Pumphouse East Elevation
1 : 50

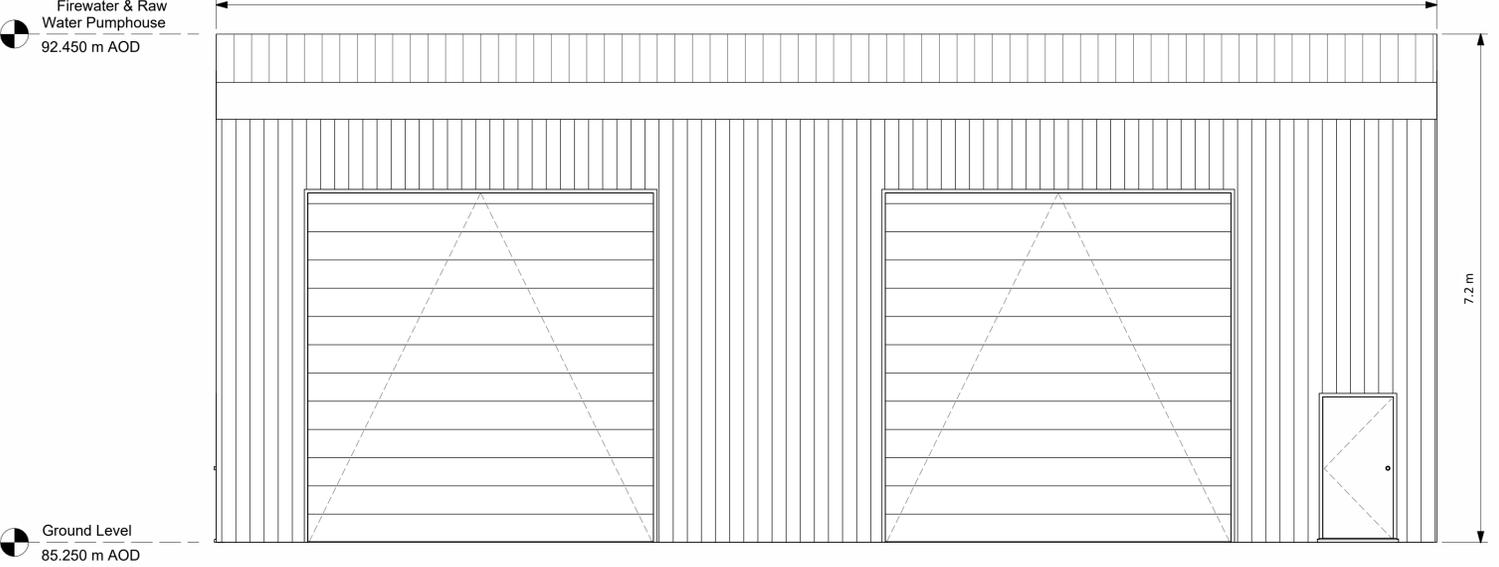

4 Fire Water Pumphouse West Elevation
1 : 50



6 Firewater Pumphouse Section B-B
1 : 50

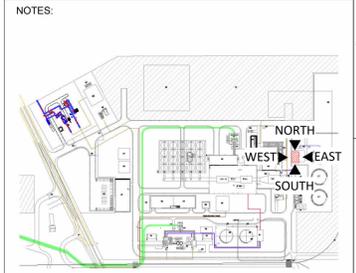

Key Plan
1 : 6000

- NOTES:
- Building colours will range within a muted mid-dark grey and green spectrum. Refer to EIA Vol. II, Appendix 10A for detail
 - Final detail of building finishes to be agreed with planning authority in advance of development commencing

R1.0	FOR PLANNING	DTW	AO1	BAB	26.01.24
REV.	DETAILS OF REVISION	DRAWN	CHKD	APR	DATE

FICHTNER
CONSULTING ENGINEERS LIMITED
7 Sir John Rogerson's Quay, Block C,
Grand Canal Docklands,
Dublin 2, D02 VK60
Tel: +353 (1) 506 0632
Website: www.fichtner.ie

CLIENT: **Bord na Móna Powergen Limited**
SITE:
PROJECT: **Derrygreenagh Power**
TITLE: **FIREWATER & RAW WATER PUMPHOUSE ELEVATIONS & SECTIONS**

DRAWN BY:	DTW	DATE:	26.01.24
CHECKED BY:	AO1	DATE:	26.01.24
APPROVED BY:	BAB	DATE:	26.01.24

FILENAME: **DUBLIN**
OFFICE OF ISSUE: **A1** | SCALE: 1:50
DRAWING No.: **S7060-8050-0023** | SHEET 01 | REVISION: **R1.0**

