


**1 Water Treatment Plant Floor Plan 85.250m AOD**  
1 : 125




**Key Plan**  
1 : 6000


- NOTES:
- Building colours will range within a muted mid-dark grey and green spectrum. Refer to EIA Vol. II, Appendix 10A for detail
  - Final detail of building finishes to be agreed with planning authority in advance of development commencing

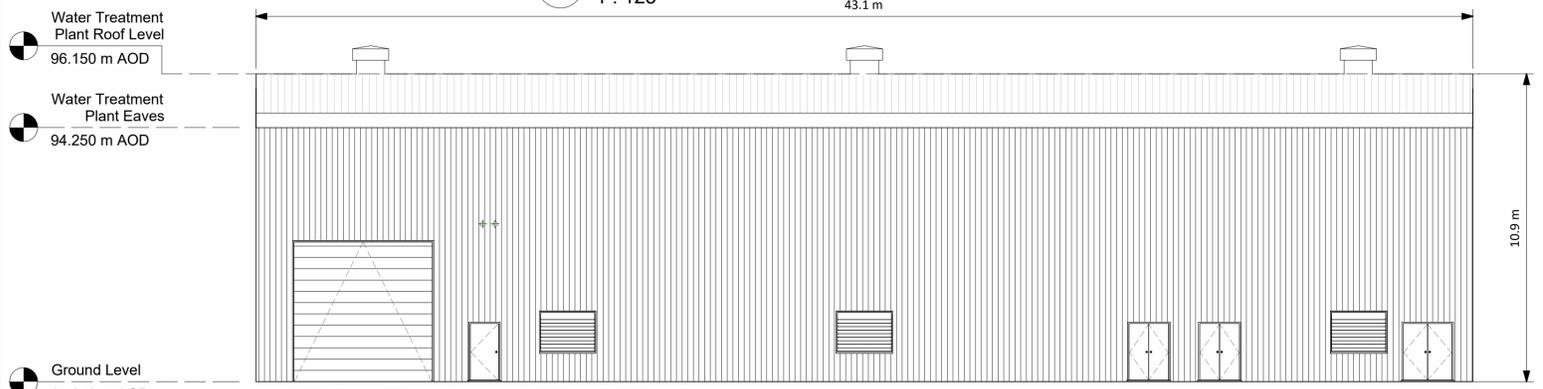


**2 Water Treatment Plant West**  
1 : 125

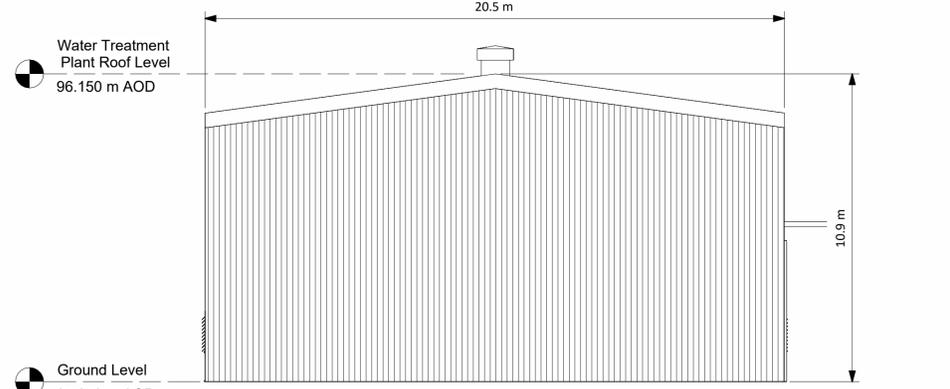


**3 Water Treatment Plant North**  
1 : 125

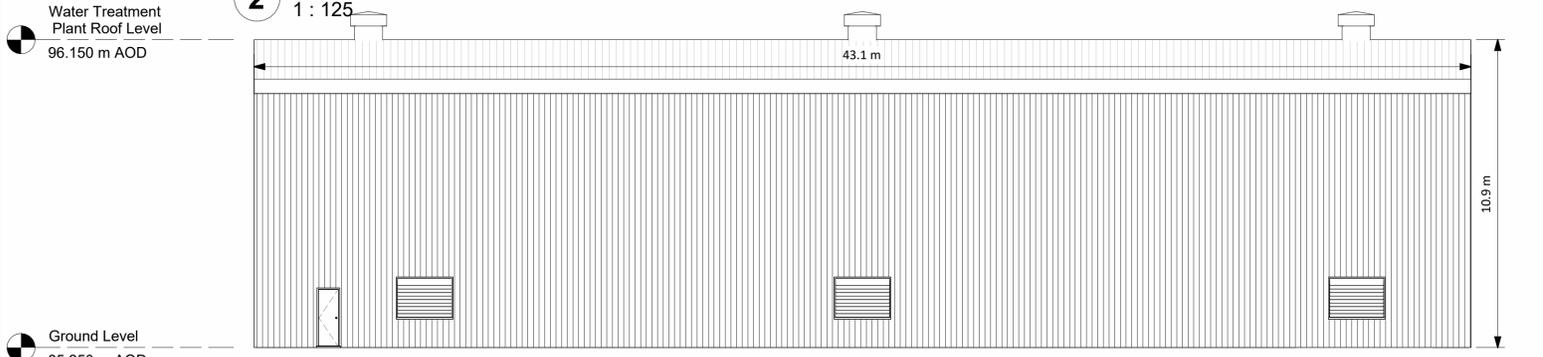


**4 Water Treatment Plant East**  
1 : 125

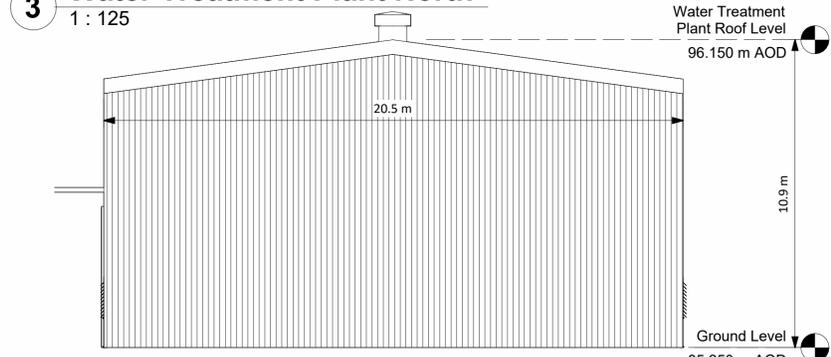

**5 Water Treatment Plant South**  
1 : 125

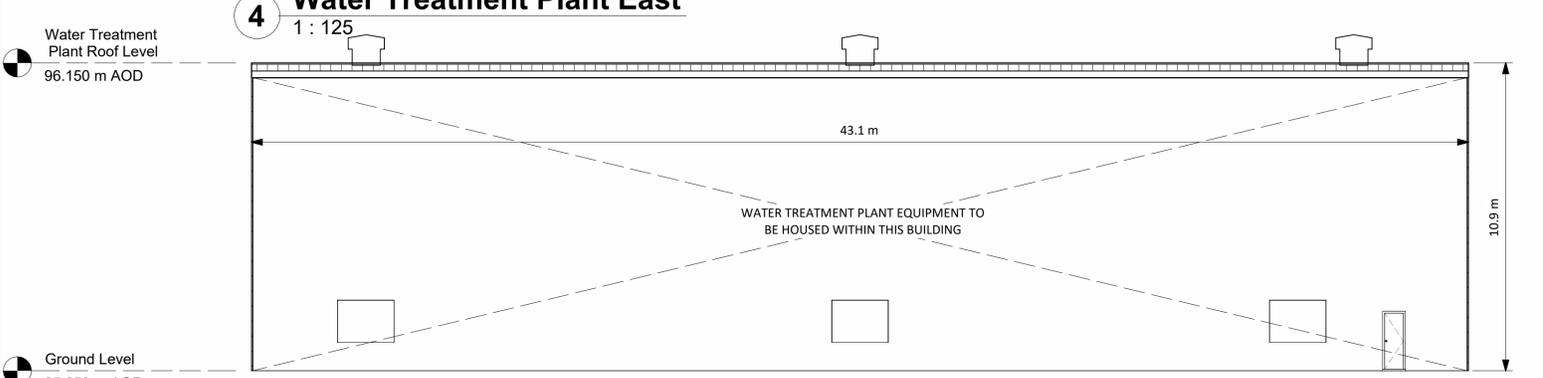

**6 Water Treatment Plant Section A-A**  
1 : 125

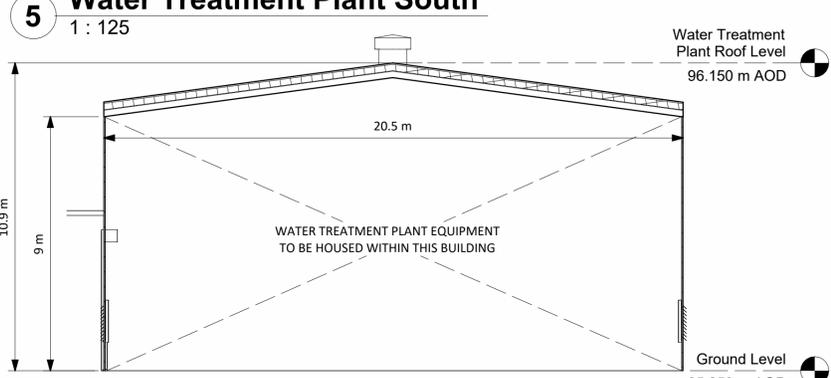

**7 Water Treatment Plant Section B-B**  
1 : 125



R1.0	FOR PLANNING	DTW	AO1	BAB	26.01.24
REV.	DETAILS OF REVISION	DRAWN	CHKD	APR	DATE

**FICHTNER**  
CONSULTING ENGINEERS LIMITED  
7 Sir John Rogerson's Quay, Block C,  
Grand Canal Docklands,  
Dublin 2, D02 VK60  
Tel: +353 (1) 506 0632  
Website: www.fichtner.ie

CLIENT: **Bord na Móna Powergen Limited**

SITE:

PROJECT: **Derrygreenagh Power**

TITLE: **WATER TREATMENT PLANT PLAN ELEVATIONS & SECTIONS**

DRAWING STATUS:	For Planning	DATE:	26.01.24
DRAWN BY:	DTW	DATE:	26.01.24
CHECKED BY:	AO1	DATE:	26.01.24
APPROVED BY:	BAB	DATE:	26.01.24

FILENAME: \_\_\_\_\_  
OFFICE OF ISSUE: \_\_\_\_\_ DUBLIN  
SHEET SIZE: \_\_\_\_\_ SCALE: 1:125  
DRAWING No.: \_\_\_\_\_ REVISION:  
**S7060-8050-0024** Sheet 1 of 1 **R1.0**