


GROUND LEVEL
85.250 m AOD




Key Plan
1 : 6000

- NOTES:
- Building colours will range within a muted mid-dark grey and green spectrum. Refer to EIA Vol. II, Appendix 10A for detail
 - Final detail of building finishes to be agreed with planning authority in advance of development commencing


1 Fire/Raw Water & Demin Water Tanks
1 : 250

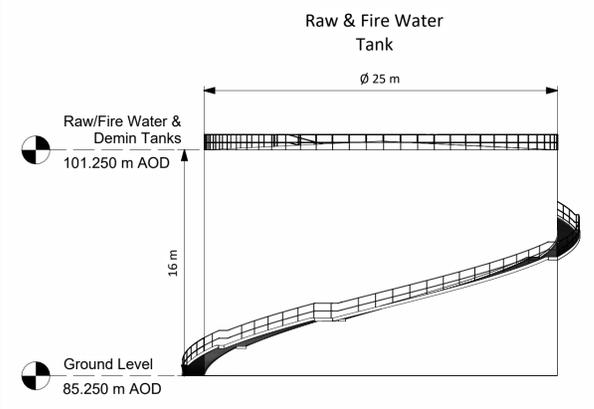


2 Fire/Raw Water & Demin Tank North Elevation
1 : 250

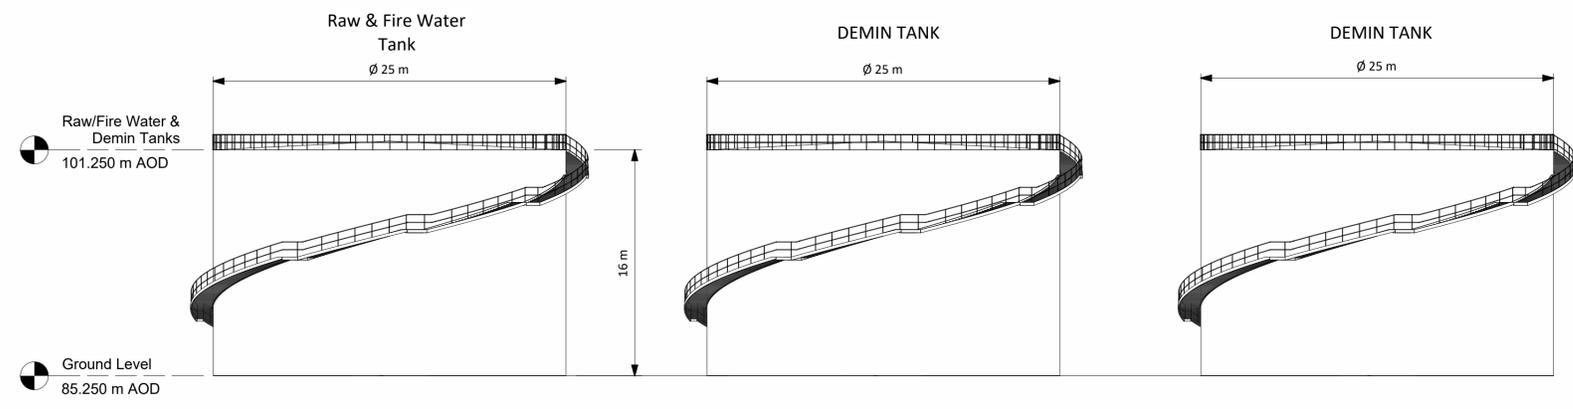


3 Fire/Raw Water & Demin Tank West Elevation
1 : 250

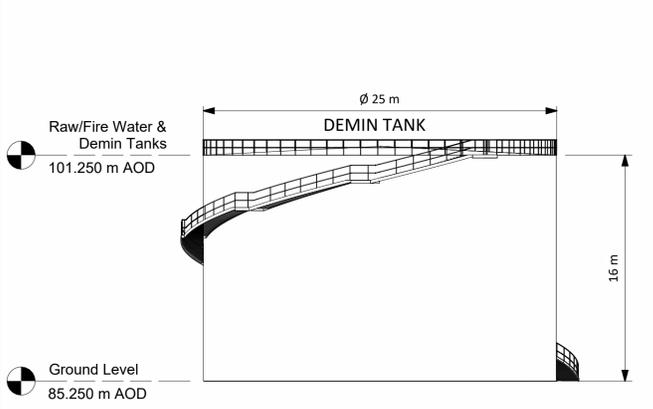

4 Fire/Raw Water & Demin Tank South Elevation
1 : 250

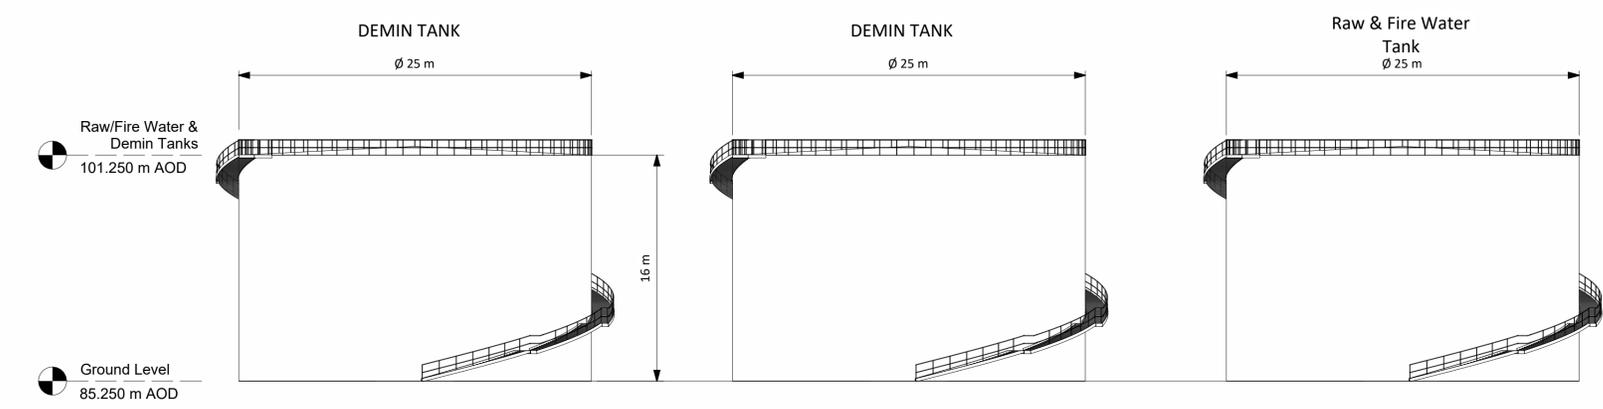

 5 Fire/Raw Water & Demin Tank East Elevation
1 : 250



R1.0	FOR PLANNING	DTW	AO1	BAB	26.01.24
REV.	DETAILS OF REVISION	DRAWN	CHKD	APR	DATE

FICHTNER
CONSULTING ENGINEERS LIMITED
7 Sir John Rogerson's Quay, Block C,
Grand Canal Docklands,
Dublin 2, D02 VK60
Tel: +353 (1) 506 0632
Website: www.fichtner.ie

CLIENT: **Bord na Móna Powergen Limited**
SITE:
PROJECT: **Derrygreenagh Power**
TITLE: **FIRE/RAW WATER & DEMIN TANK
PLAN ELEVATIONS & SECTIONS**

DRAWING STATUS:	For Planning
DRAWN BY:	DTW
CHECKED BY:	AO1
APPROVED BY:	BAB
DATE:	26.01.24

OFFICE OF ISSUE: **DUBLIN**
SHEET SIZE: **A1** SCALE: 1:250
DRAWING No.: **S7060-8050-0025** REVISION: **R1.0**
Sheet 1 of 1