



1 GRF Floor Plan 82.250m AOD
1 : 200

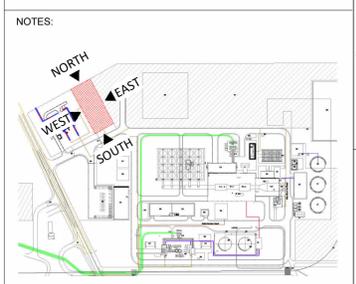


Key Plan
1 : 6000

- NOTES:
- Building colours will range within a muted mid-dark grey and green spectrum. Refer to EIAR Vol. II, Appendix 10A for detail
 - Final detail of building finishes to be agreed with planning authority in advance of development commencing

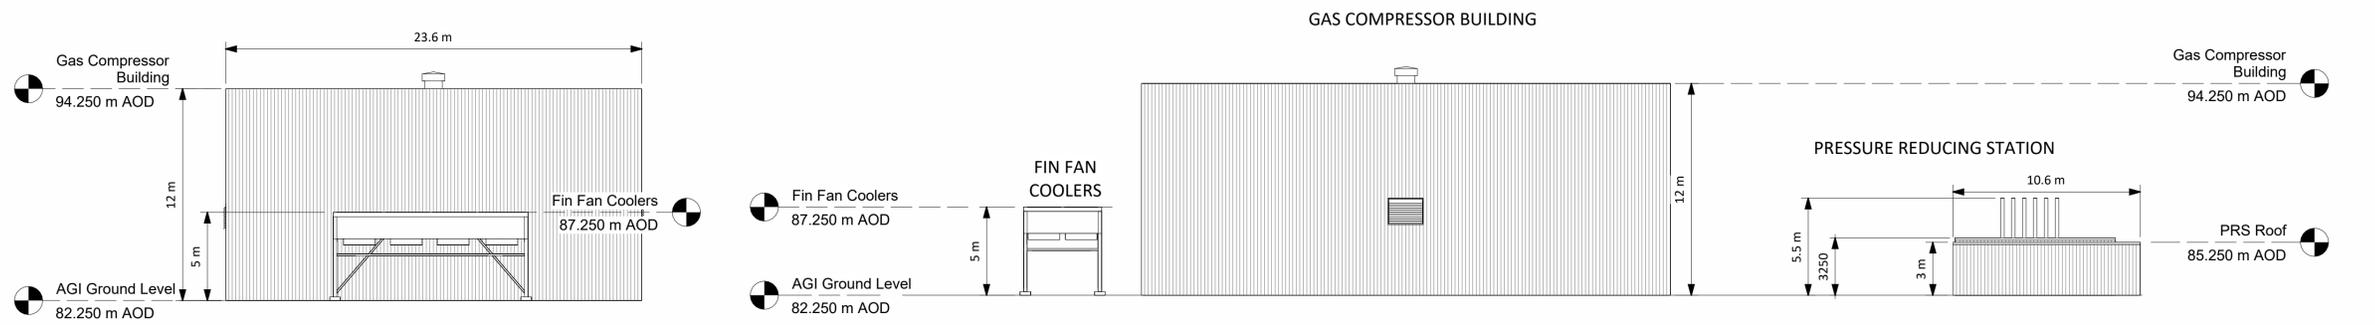


2 GRF North Elevation
1 : 200

3 GRF West Elevation
1 : 200

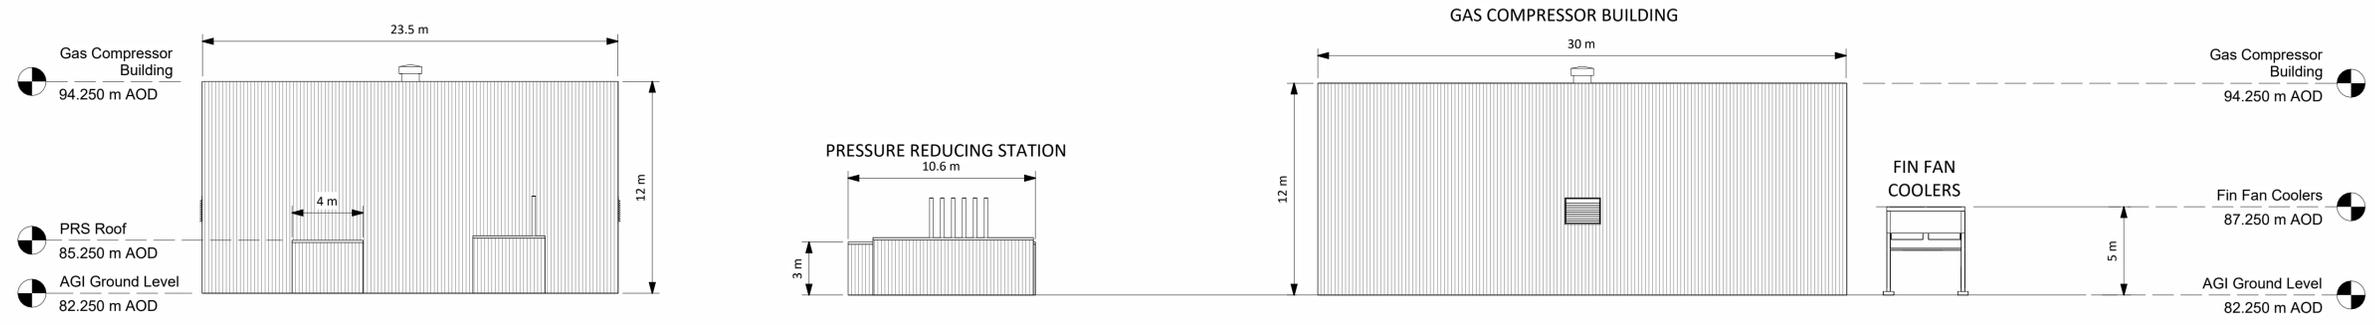

4 GRF South Elevation
1 : 200

5 GRF East Elevation
1 : 200

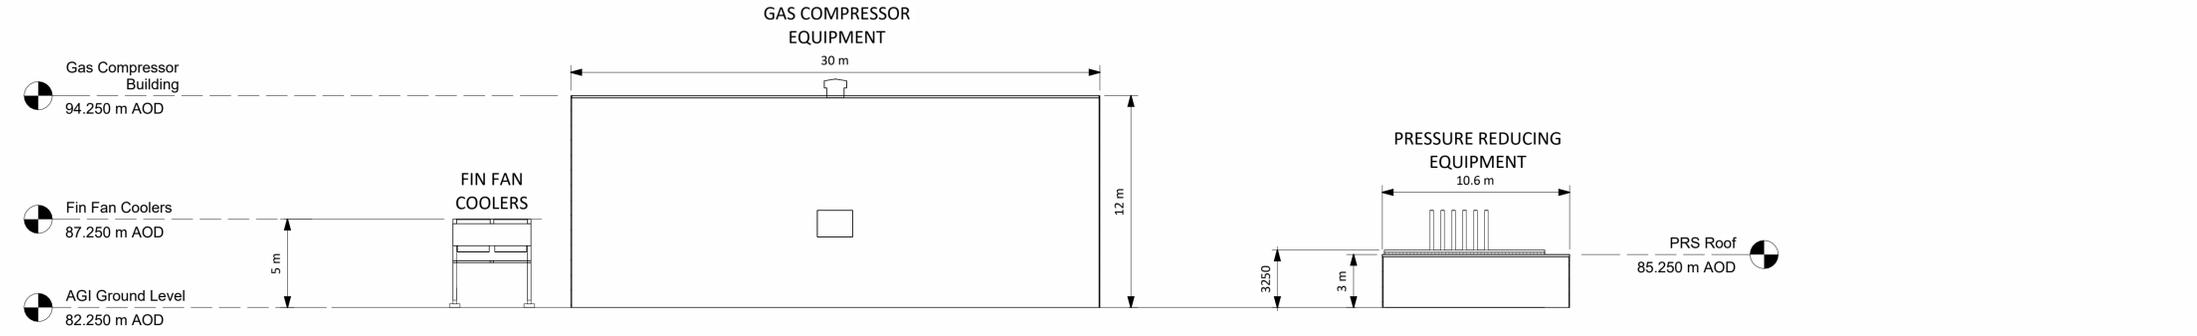

6 GRF Section A-A
1 : 200



REV.	DETAILS OF REVISION	DTW	AO1	BAB	26.01.24
R1.0	FOR PLANNING	DTW	AO1	BAB	26.01.24
		DRAWN	CHKD	APR	DATE

FICHTNER
CONSULTING ENGINEERS LIMITED
7 Sir John Rogerson's Quay, Block C,
Grand Canal Docklands,
Dublin 2, D02 VK60
Tel: +353 (1) 506 0632
Website: www.fichtner.ie

CLIENT: **Bord na Móna Powergen Limited**

SITE:

PROJECT: **Derrygreenagh Power**

TITLE: **GAS RECEIVING FACILITY
PLAN ELEVATIONS & SECTIONS**

DRAWN BY:	DTW	DATE:	26.01.24
CHECKED BY:	AO1	DATE:	26.01.24
APPROVED BY:	BAB	DATE:	26.01.24
FILENAME:			
OFFICE OF ISSUE:	DUBLIN		
SHEET SIZE:	A1	SCALE:	1:200
DRAWING No.:	S7060-8050-0030		

REVISION: **R1.0**
Sheet 1 of 1